




Revised Layout of Paikgacha 132/33 kV SS

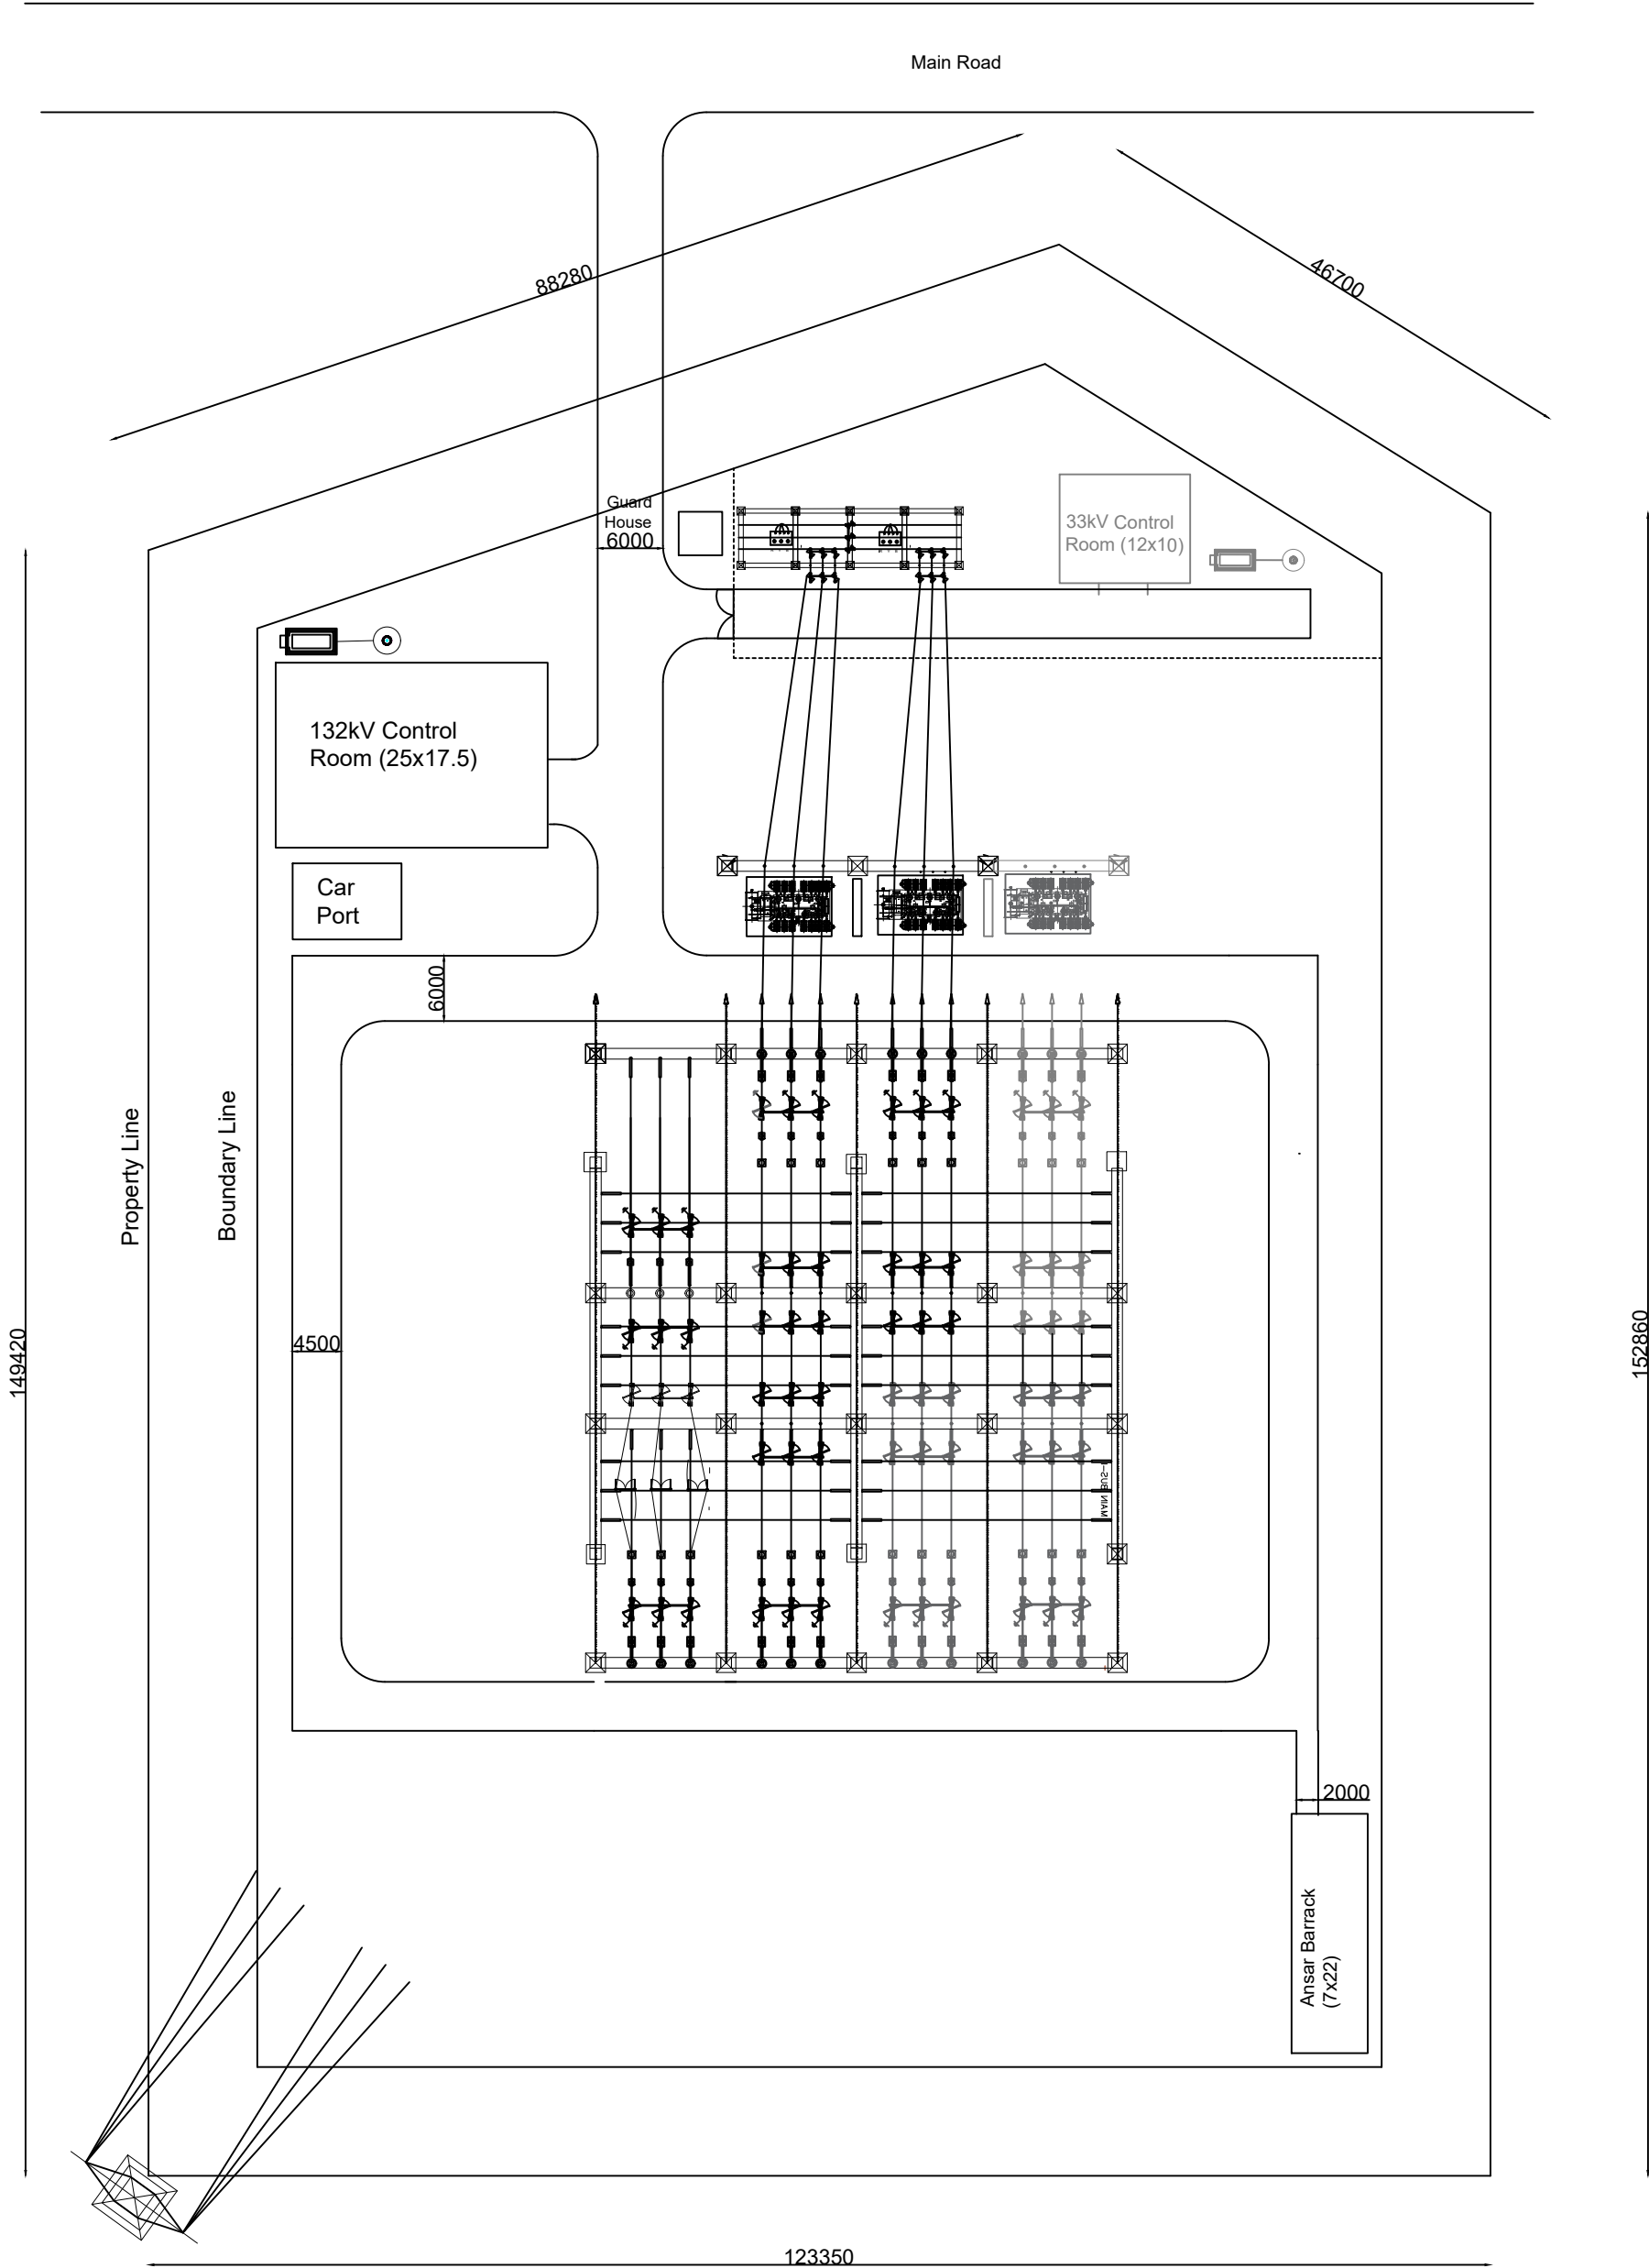

Revised Layout of Mathbaria 132/33 kV SS

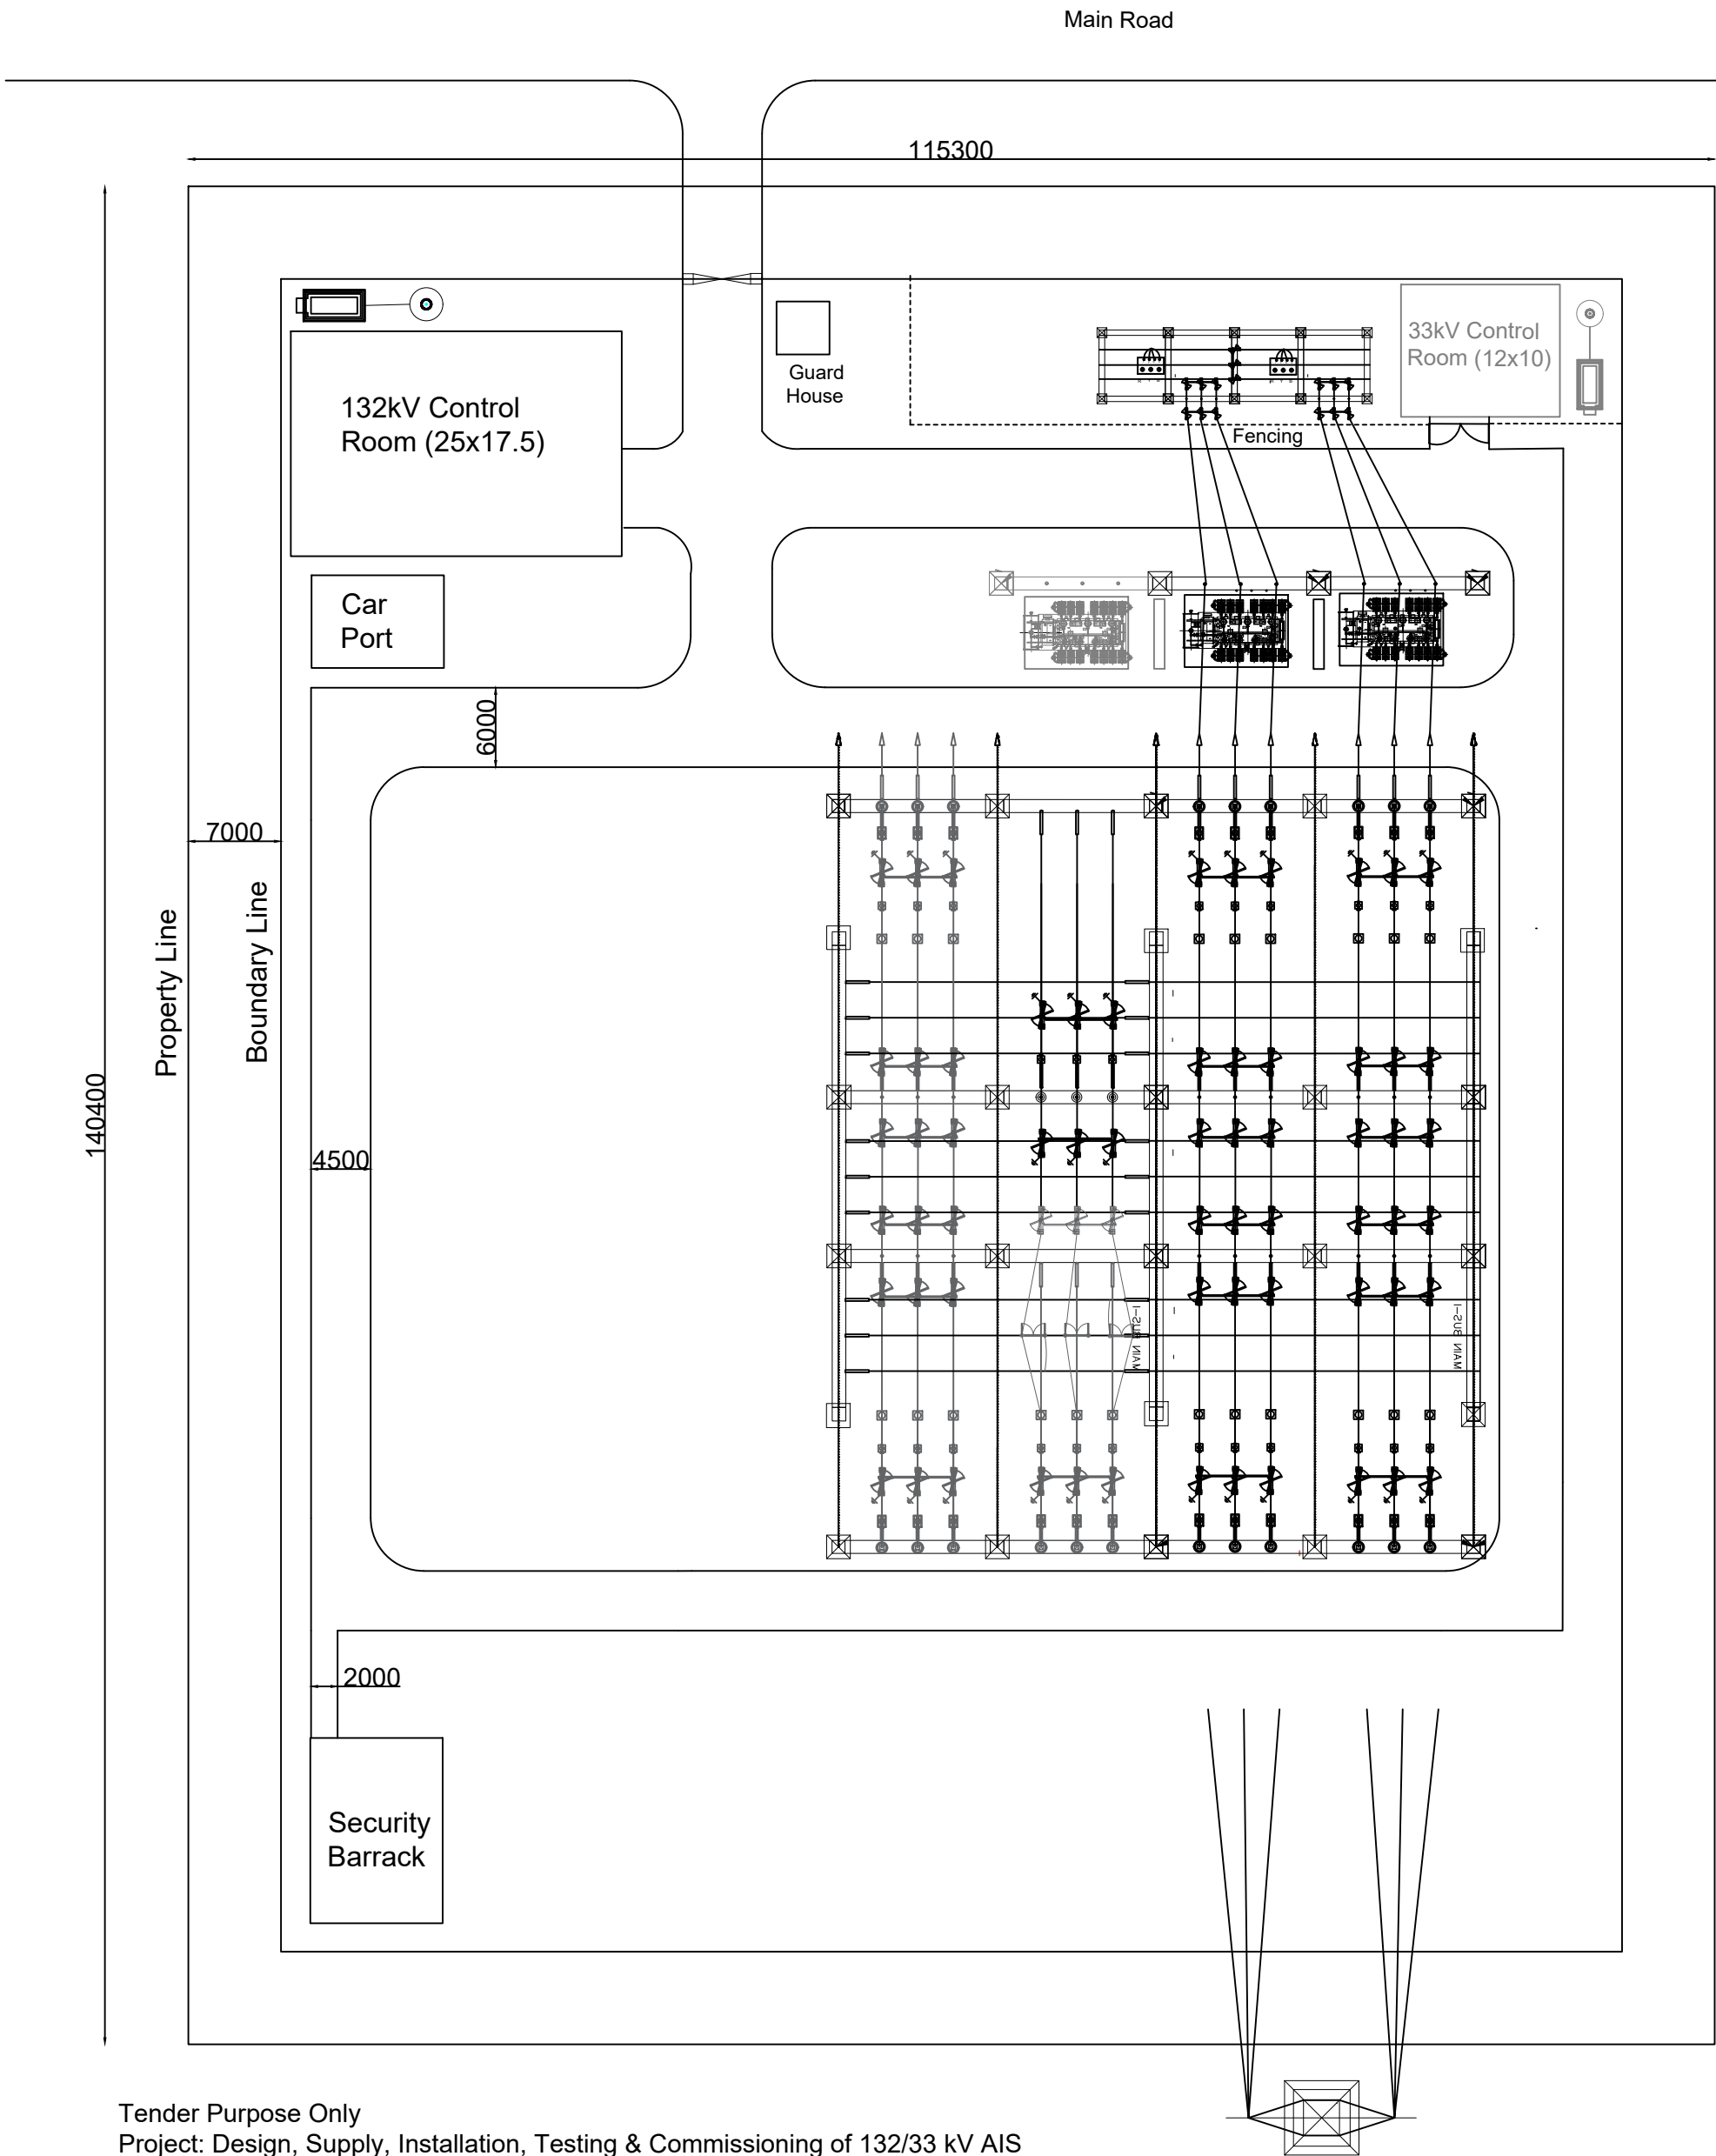

Tender Purpose Only
Project: Design, Supply, Installation, Testing & Commissioning of 132/33 kV AIS
Substation at Paikgacha and 132/33 kV AIS Substation at Mathbaria including associated
132KV bay extension at Sathkhira 132/33kV grid substation & at Bhandaria 132/33kV grid
substation on turnkey basis (Package-3)
Title: MATHBARIA 132/33KV AIS SS LAYOUT
Drawing no: PG/ADB/LAY_all , Sheet 2 of 4

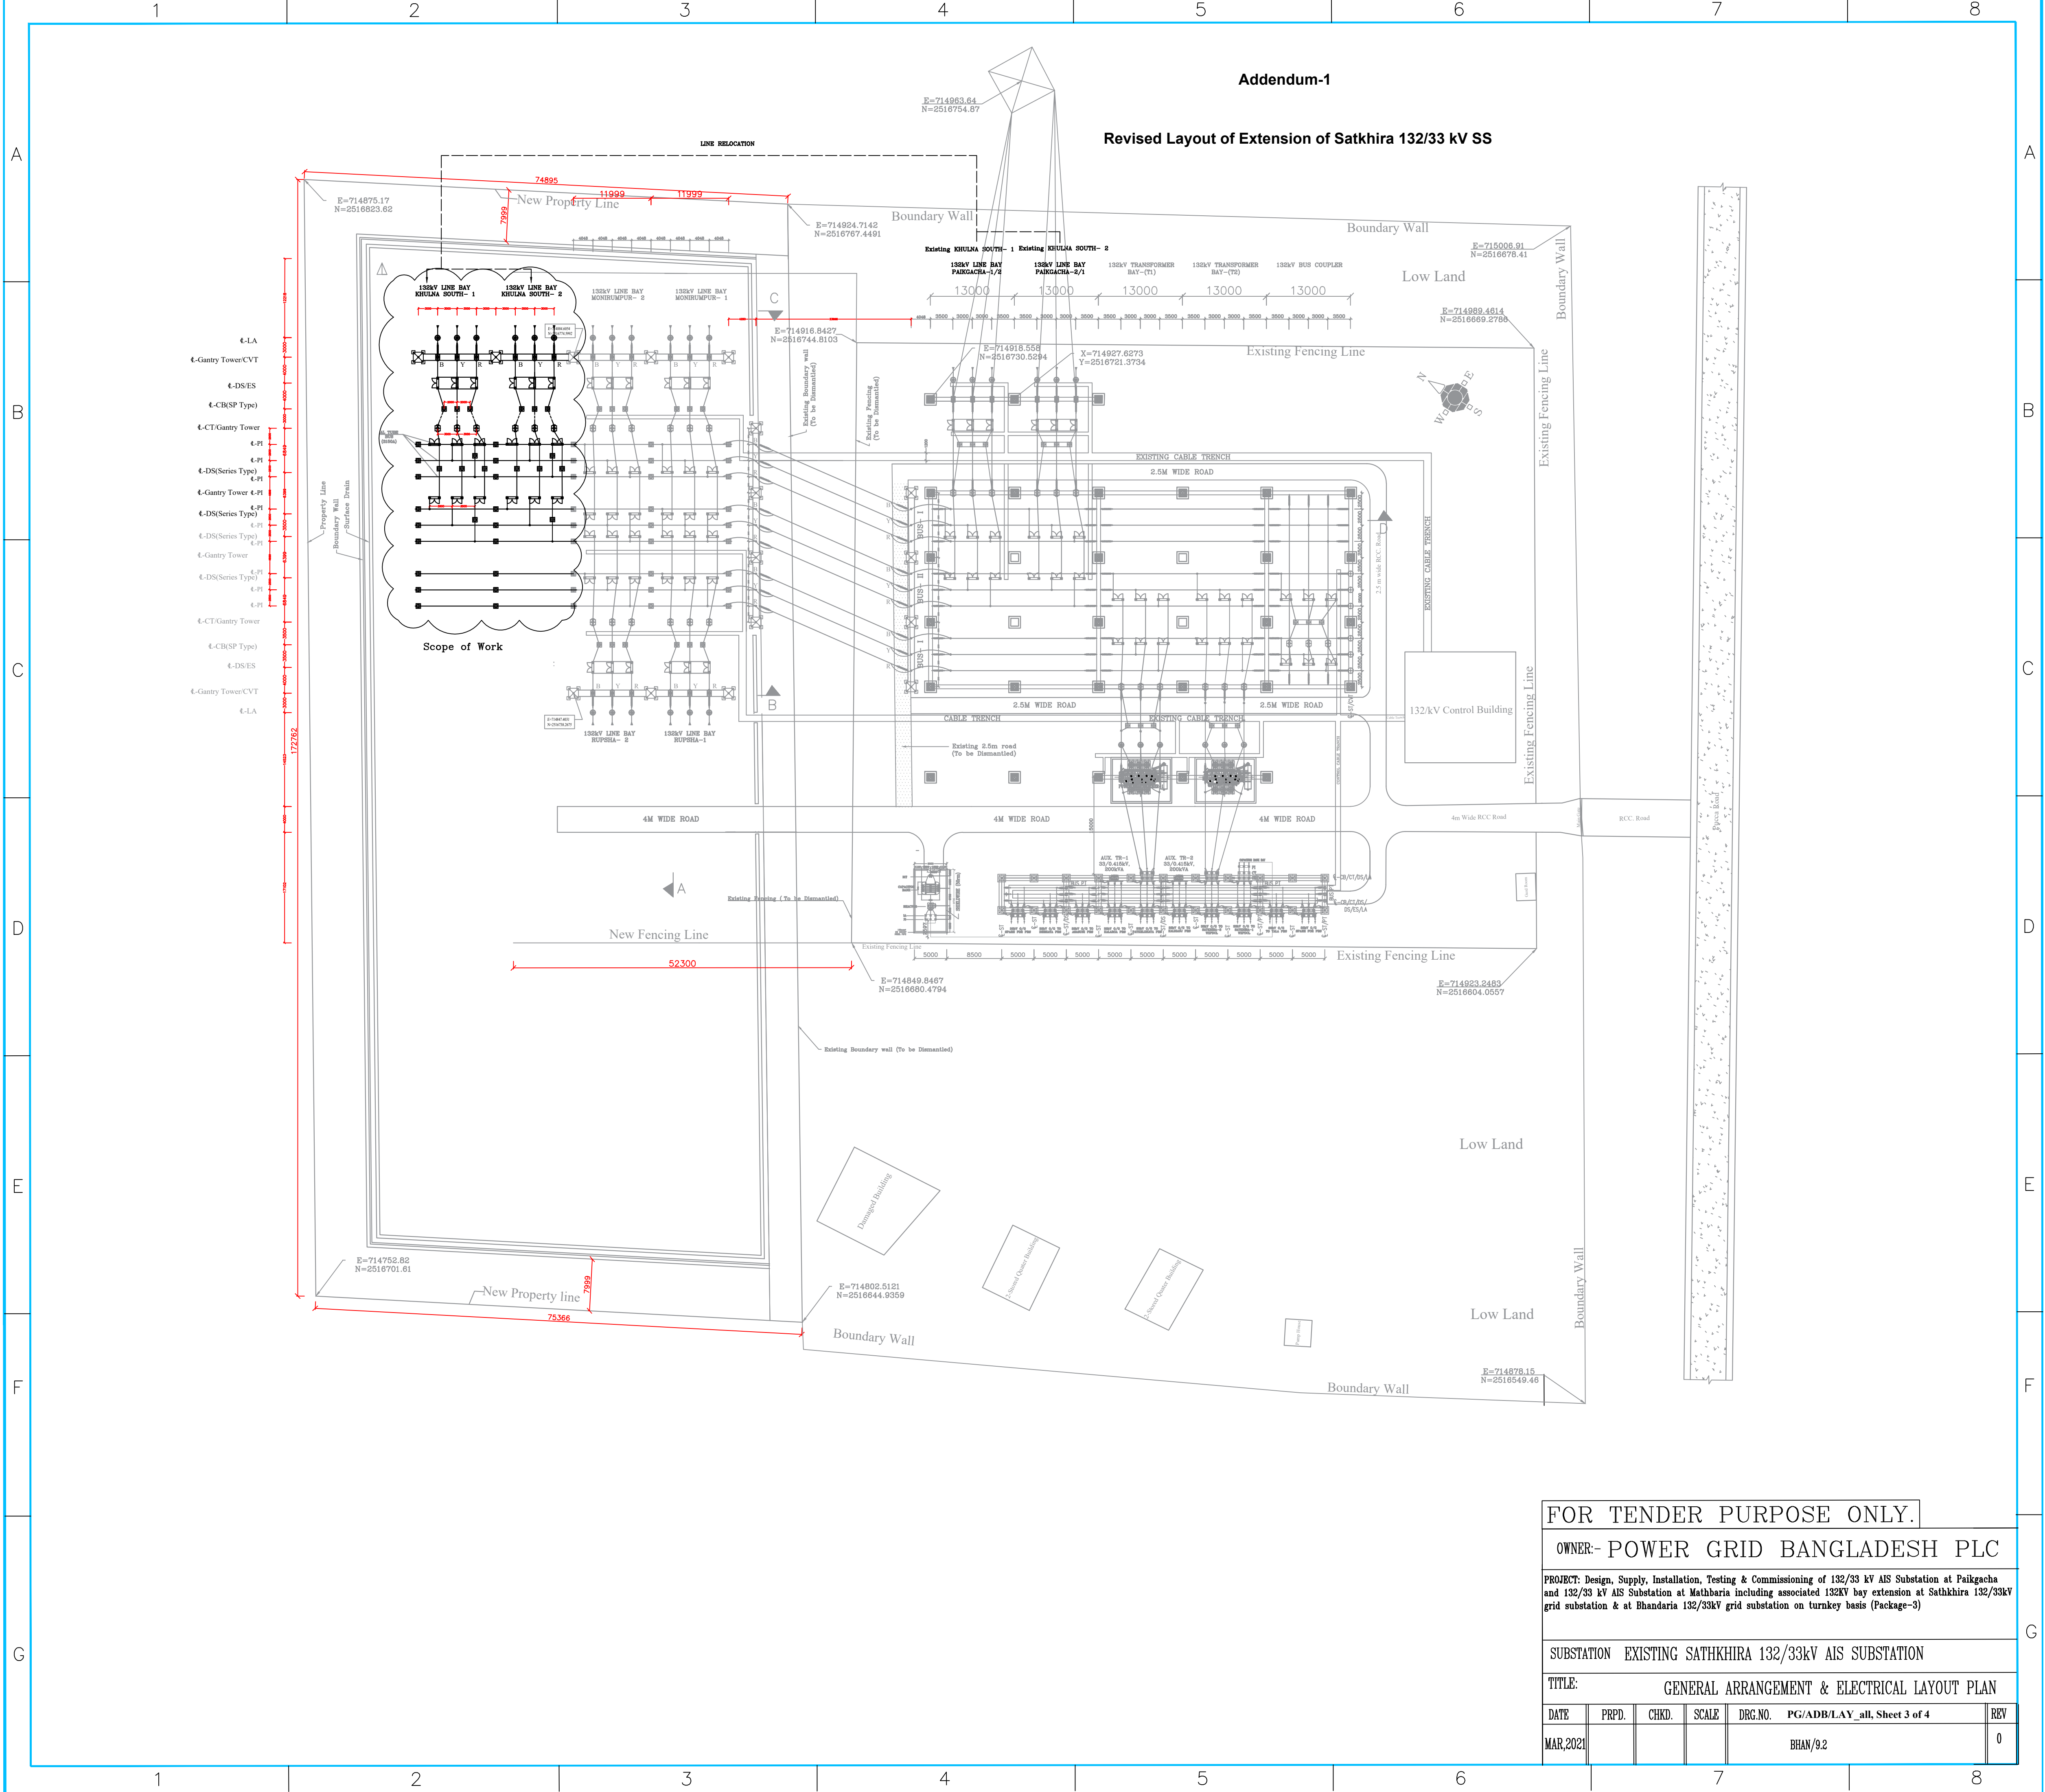

FOR TENDER PURPOSE ONLY.						
OWNER:- POWER GRID BANGLADESH PLC						
PROJECT: Design, Supply, Installation, Testing & Commissioning of 132/33 kV AIS Substation at Paikgacha and 132/33 kV AIS Substation at Mathbaria including associated 132KV bay extension at Sathkira 132/33kV grid substation & at Bhandaria 132/33kV grid substation on turnkey basis (Package-3)						
SUBSTATION EXISTING SATHKHIRA 132/33kV AIS SUBSTATION						
TITLE: GENERAL ARRANGEMENT & ELECTRICAL LAYOUT PLAN						
DATE	PRPD.	CHKD.	SCALE	DRG.NO.	PG/ADB/LAY_all, Sheet 3 of 4	REV
MAR,2021					BHAN/9.2	0



Project: Design, Supply, Installation, Testing & Commissioning of 132/33 kV AIS Substation at Paikgacha and 132/33 kV AIS Substation at Mathbaria including associated 132KV bay extension at Sathkhira 132/33kV grid substation & at Bhandaria 132/33kV grid substation on turnkey basis (Package-3)

Title: 33 kV Auxiliary Transformer Connection Scheme
Drawing No: PG/ADB/ Aux