


Annexure-1

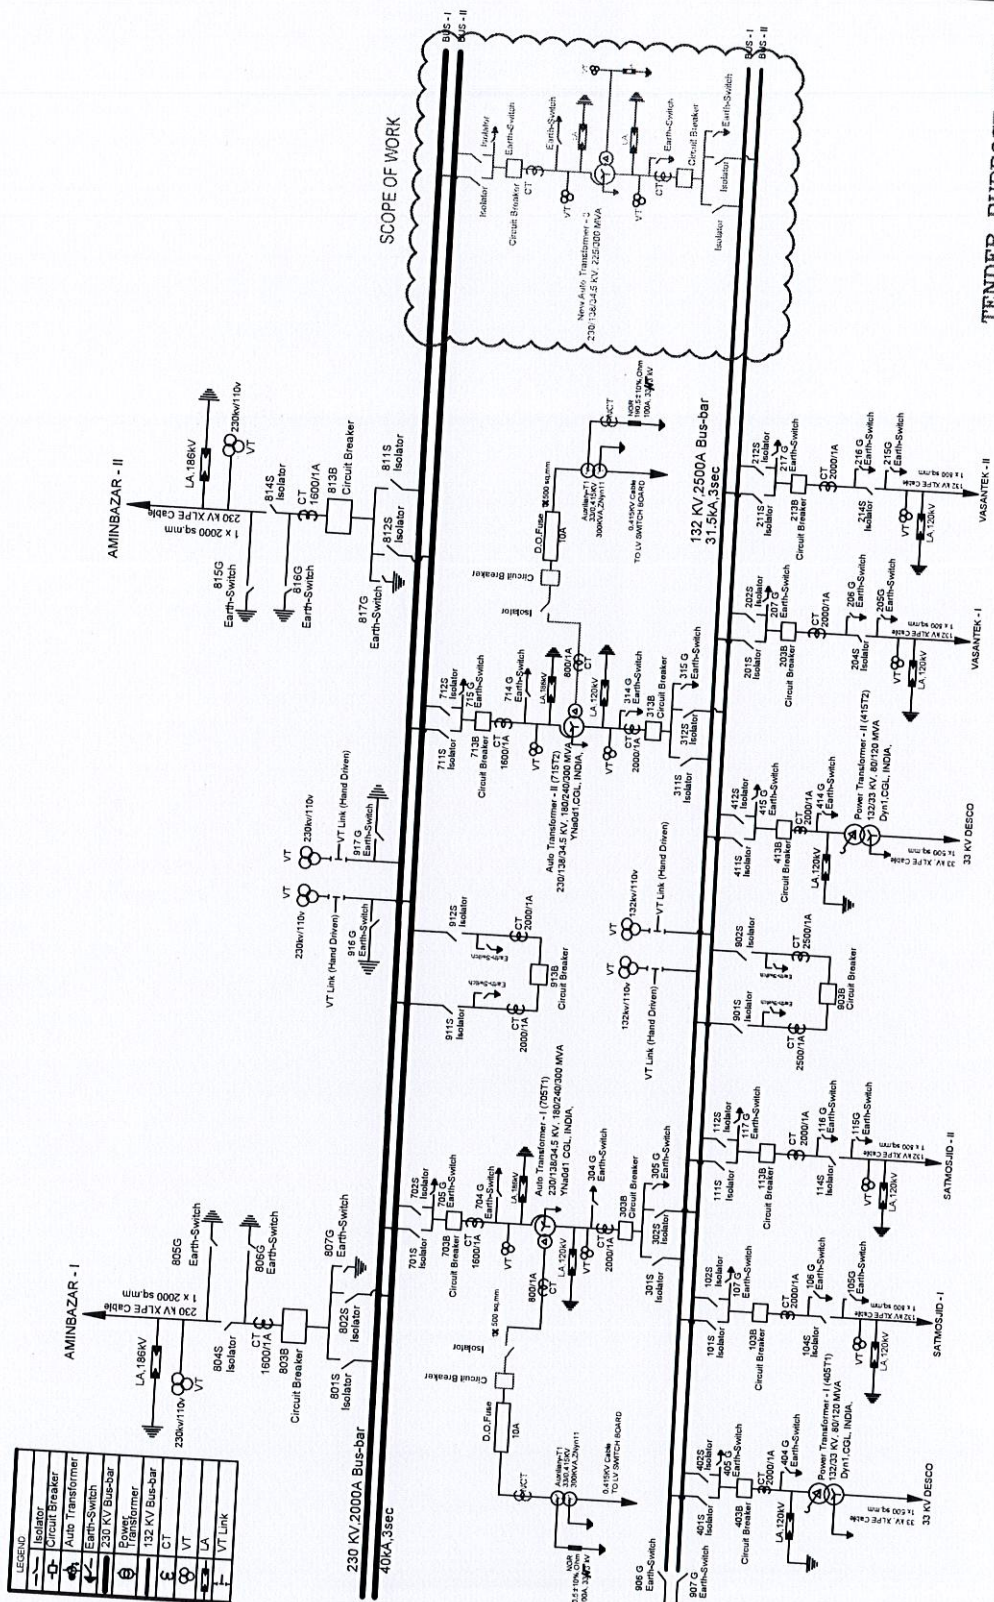

TENDER PURPOSE ONLY

 POWER GRID COMPANY OF BANGLADESH LIMITED		Single, Single Installation and Commissioning of Power Transmission and Cables for the purpose of the project on existing 132 kV line, Capacity Enhancement of Existing Grid Substations and Power Distribution (P.D.) Schemes (Enforcement of the Bangladesh Electricity Law, 1996)	
Project		ESTDING-GANGAKHOL 130/132KV IV GR SUBSTATION	
Item Name		SINGLE LINE DIAGRAM	
Drawing Name		Checked	Reviewed
Designated		Approved	Exec
Drawing No.		Date	
PGCD/2023/0224/130/132KV IV GR SUBSTATION		02/05/2023	